

A1

PLEASE NOTE:

All drawings are for the purposes of planning only unless marked for construction.


All builders to site measure to confirm measurements and layout for setting out, especially door and window positions.

Report all discrepancies to the person named below, do not proceed without instruction.


BRO take no responsibility should any drawing/s unless specified are used for building purposes and measurements should be checked on site.

All drawings remain the property of BRO Architecture

1
1 : 50
First Floor Plan

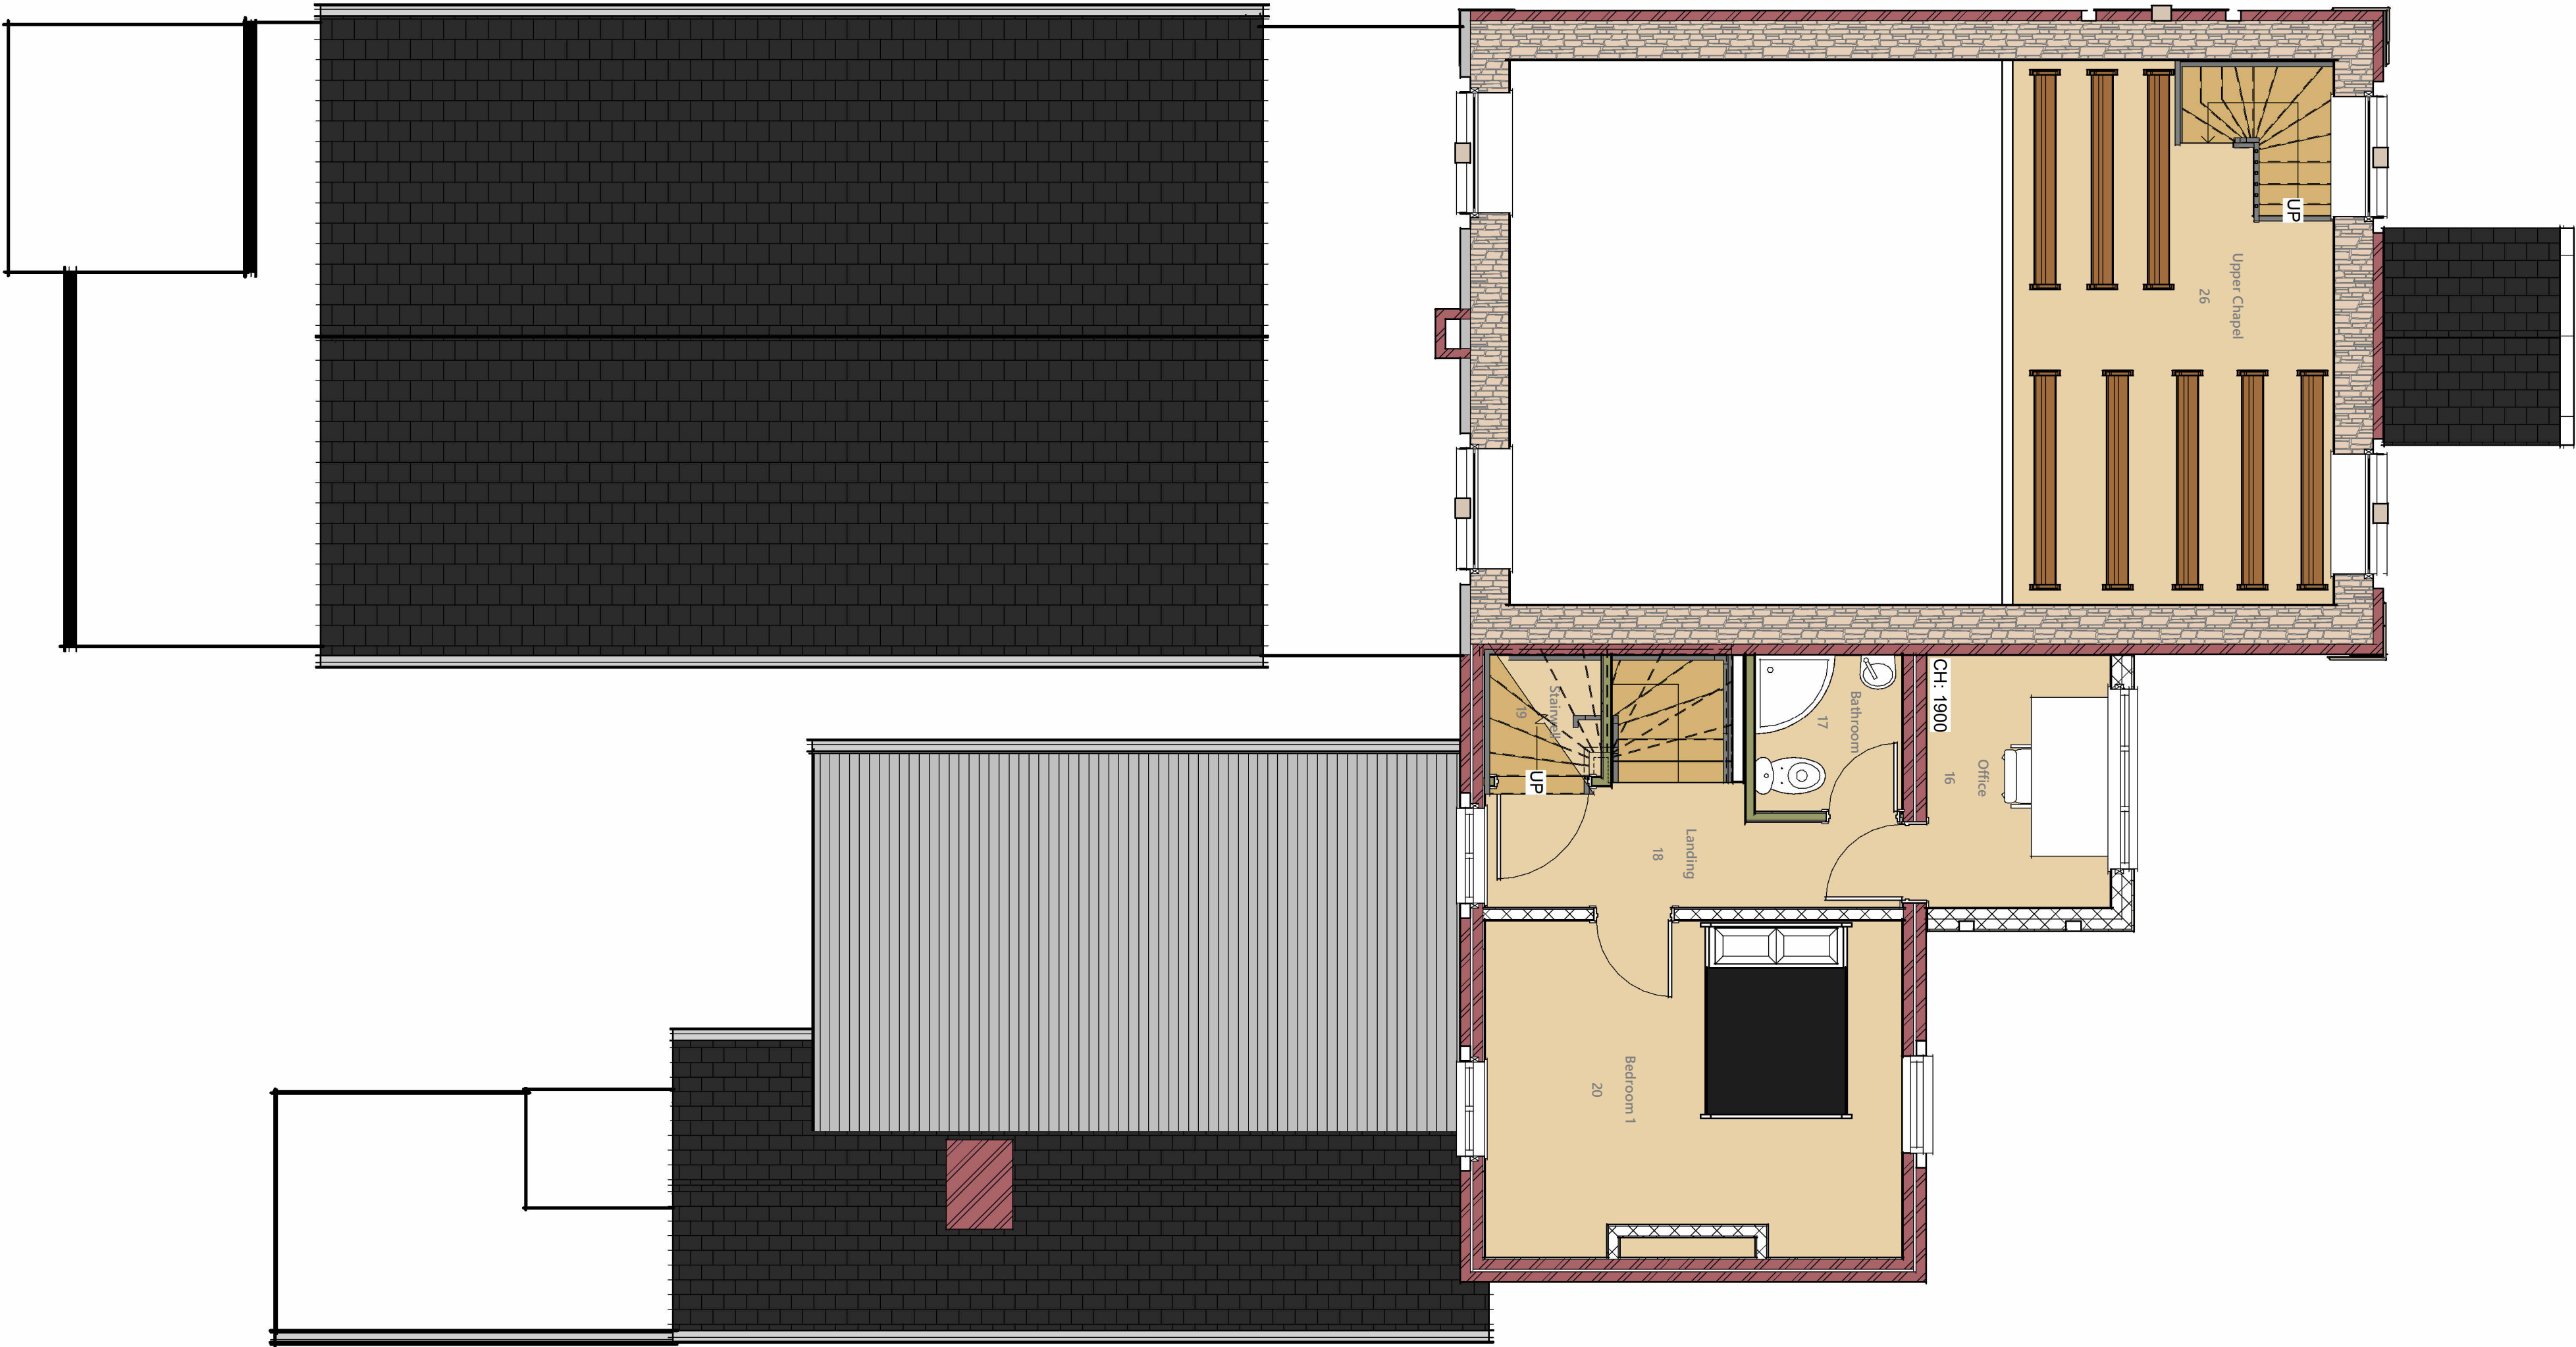

Wall Structure Key:

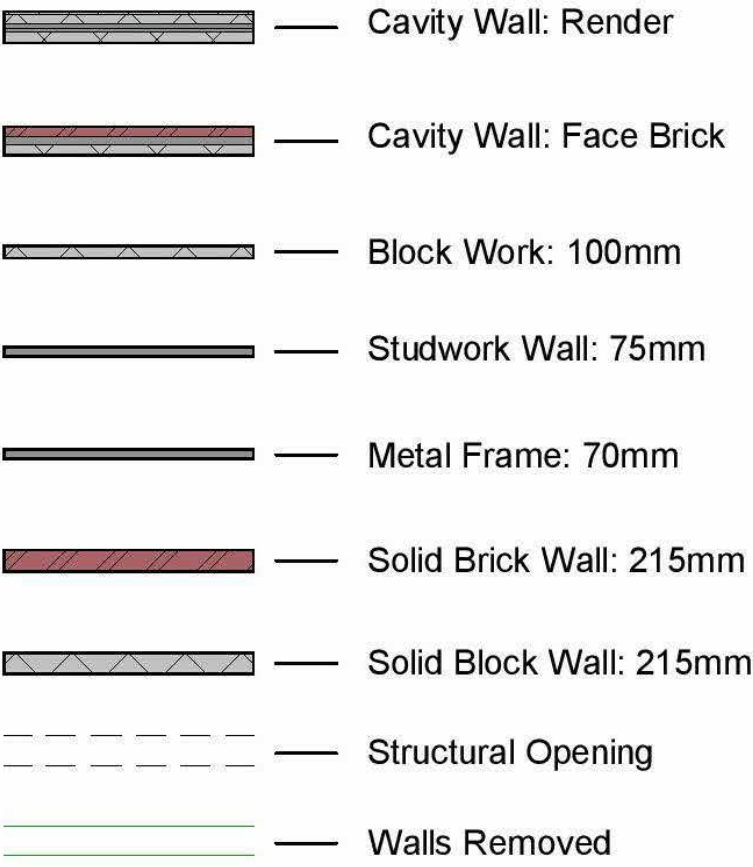


Ducting Colour & Use

Red	Electric cable
Yellow	Gas Pipe
Blue	Water pipes
Green	Data/Comms
Grey	BT
Purple	Security - Cameras
Orange	Garden Lighting non Security


Drainage Key

S	Storm Drainage
MH	Manhole
FD	Foul Drainage
SVP	Soil Vent Pipe
GP	Gulley Pot
RWP	Rainwater Pipe
AD	ACO Drain

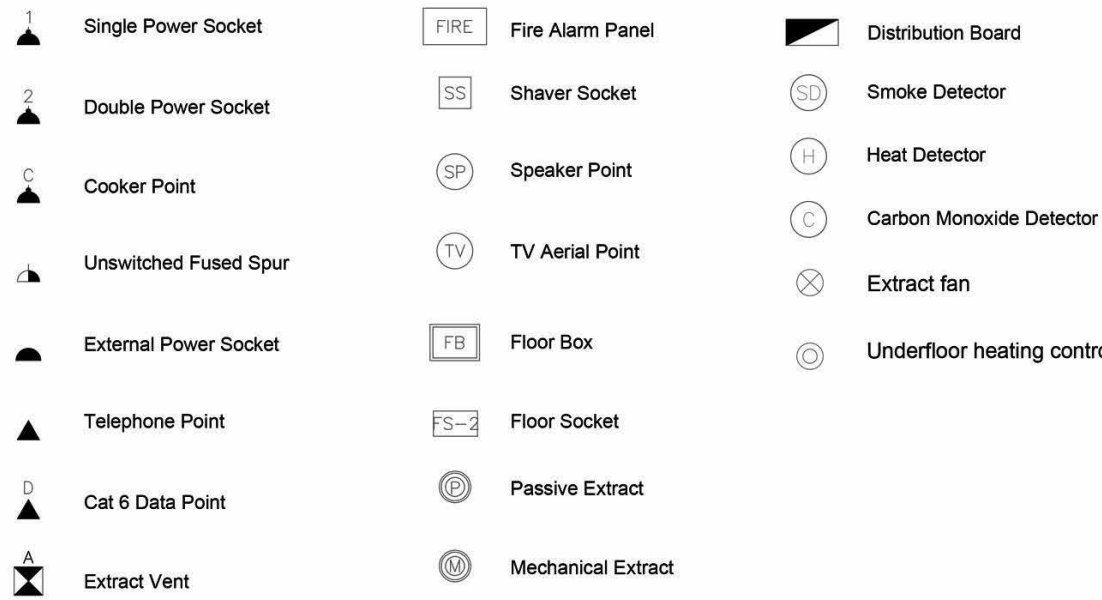

DRAWING NUMBER

E1-5

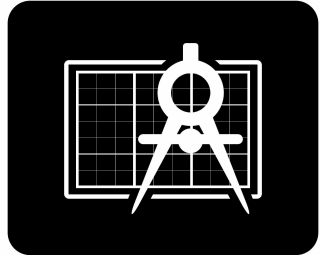

BRO ARCHITECTURE
DESIGNING YOUR DREAMS

Mobile: 07508 856621
Website: www.broarchitecture.co.uk
E-mail: info@broarchitecture.co.uk

CLIENT

Kelly Glover

SITE ADDRESS

The Manse and Baptist
Chapel 86 Bradenstoke
SN15 4EL

PROJECT NAME

Proposed Extension and
Renovation

DRAWING NAME

Existing First Floor Plan

DATE
7th Nov 25

REV

DRAWN BY
SH

CHECKED BY
Client

SCALE (@ A1)
1 : 50

PROJECT NUMBER
SH/BRO/071125-K