



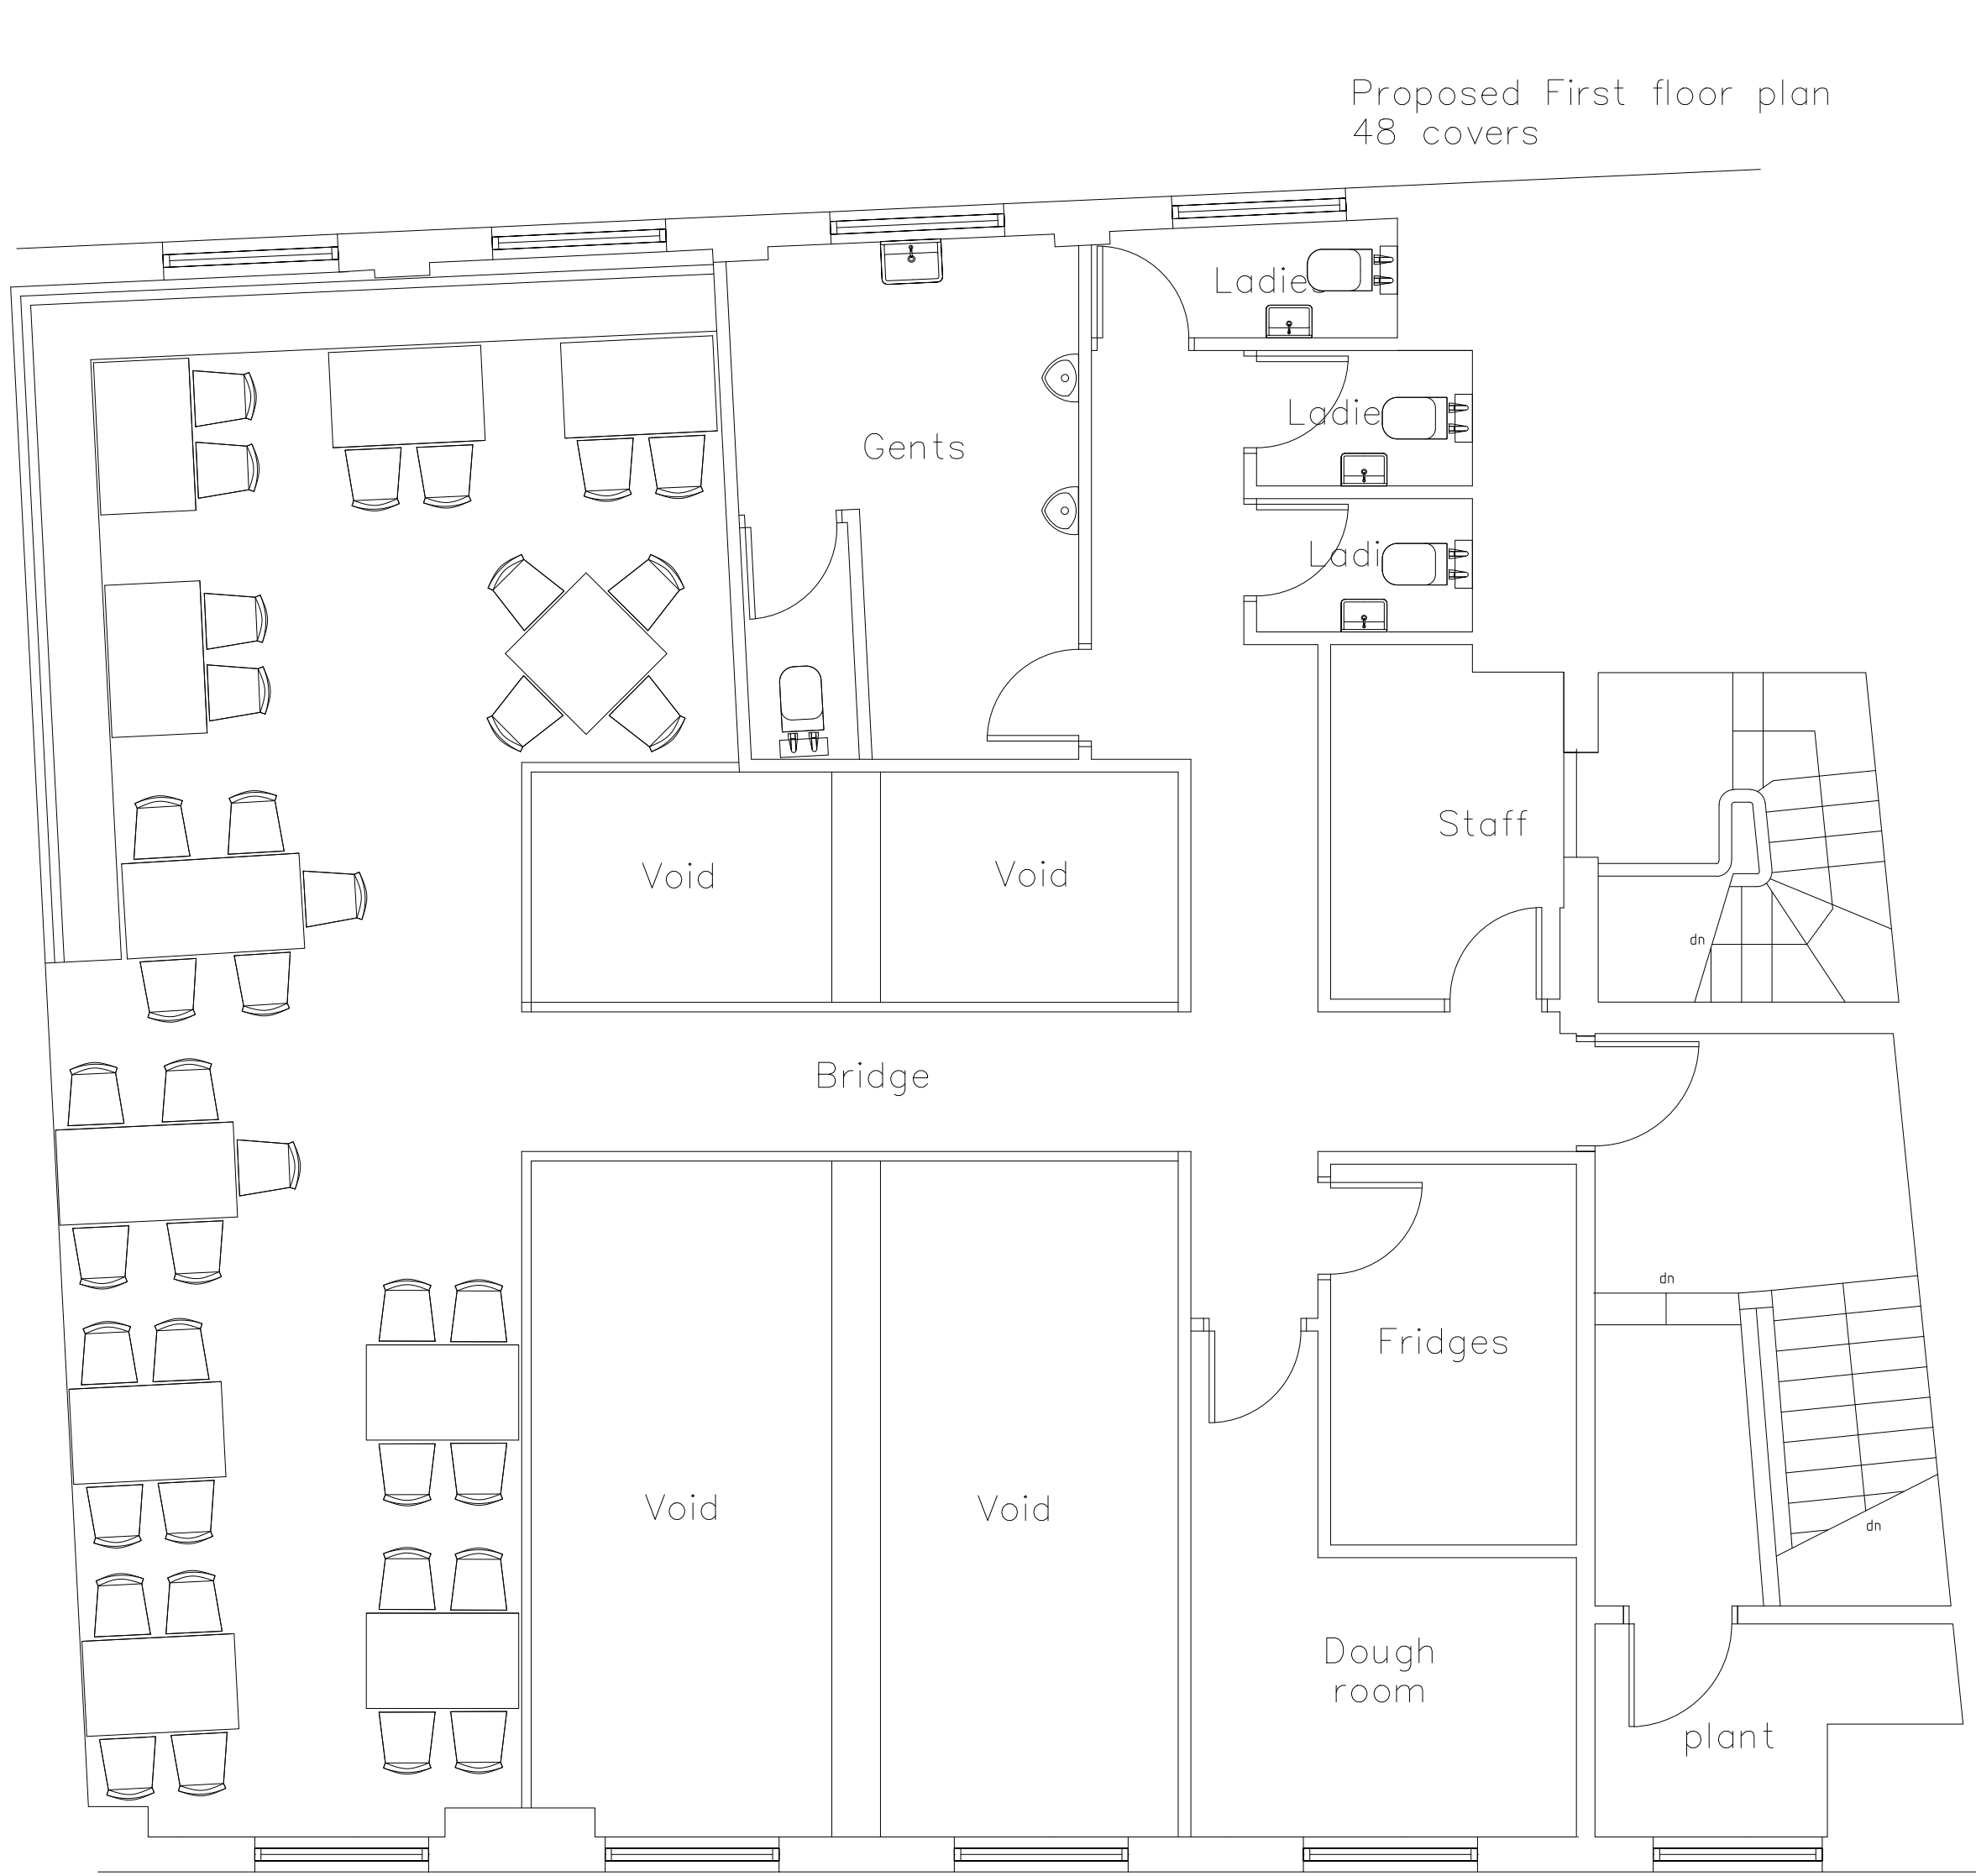

PROPOSED FIRST FLOOR PLANS

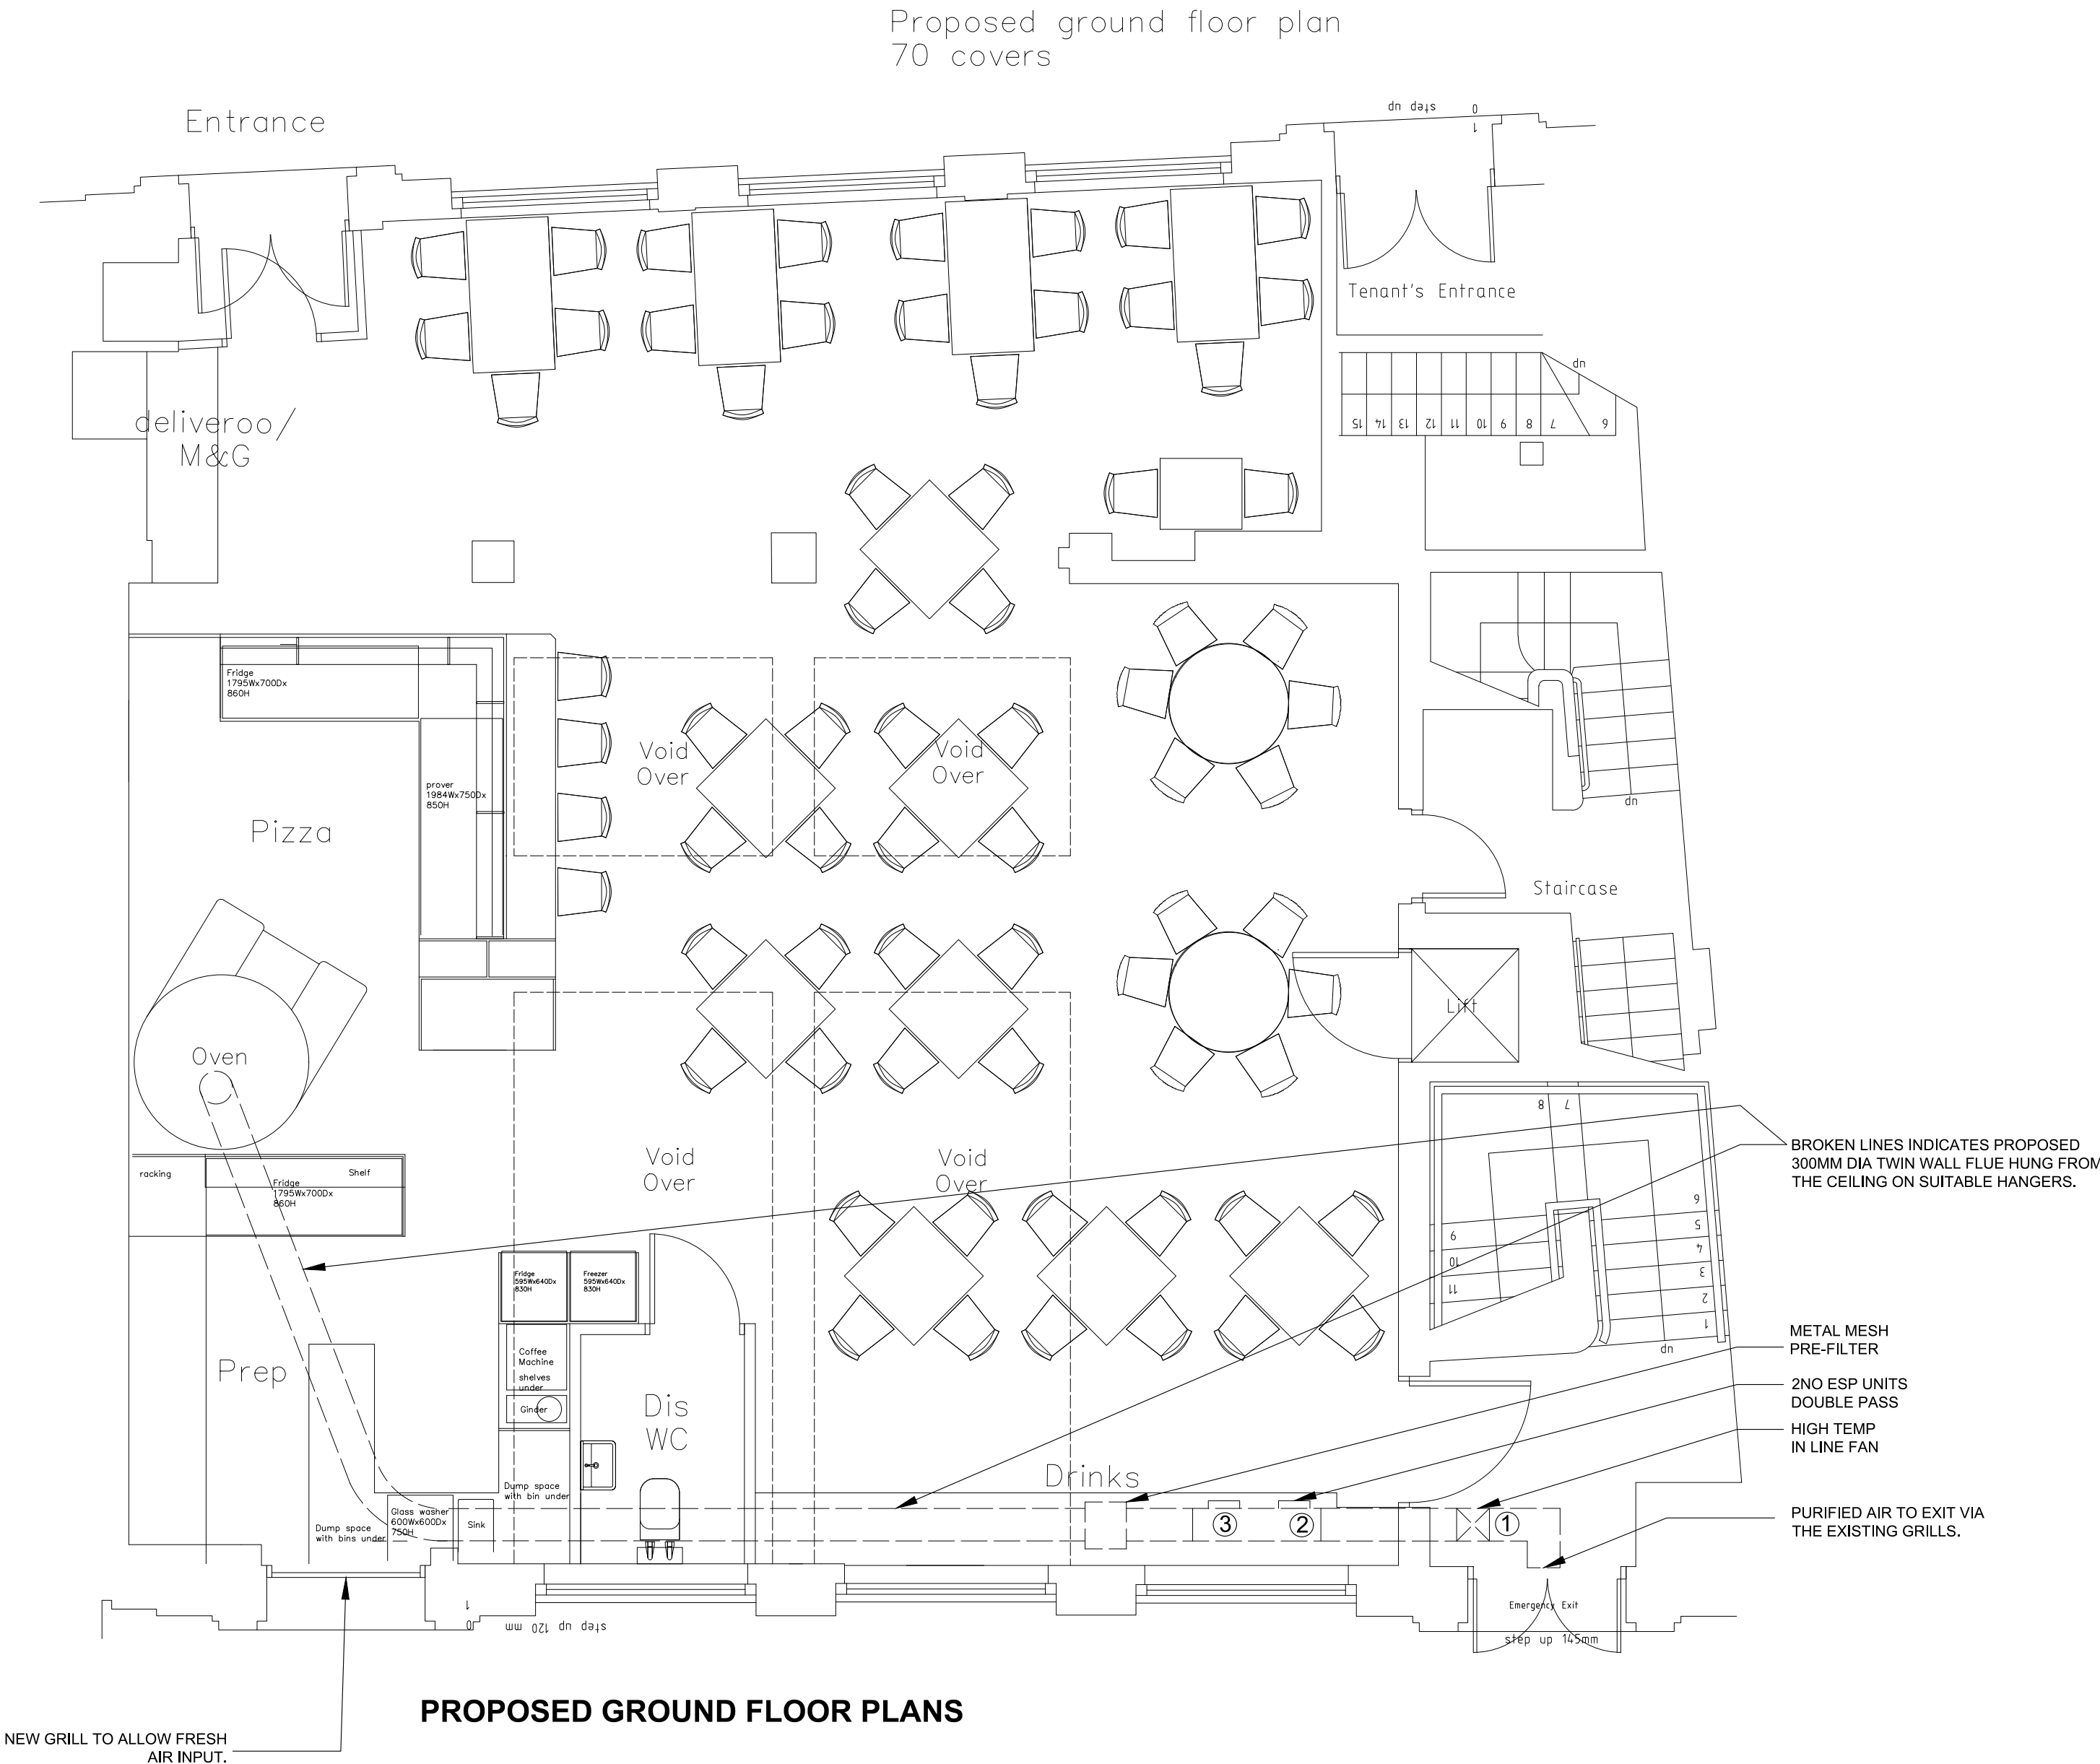

PROPOSED GROUND FLOOR PLANS

Equipment Schedule																
#REF	System	Manufacturer	Model	Electrical supply	Phase	Fuse Rating (amp)	No. of Power Cable Cores	Input Power (Watt)	FLC (amp)	Start Current (amp)	Sound Pressure level dB(A)	Weight (Kg)	No. Interconnecting Cable Cores	CONTROLLER POSITION	COMMENTS	
01	PIZZA OVEN FLUE EXTRACT FAN	FLAKT WOODS	31JMHT/16/2//5	220 - 240v, 50Hz	Single	-	3	900w	1.95	9.78	64@3m	31	3+E	BEHIND PIZZA STATION	POWER TO CONTROLLER	
02	PIZZA OVEN FLUE ESP UNIT	PURIFIED AIR	ESP 1500EI	220 - 240v, 50Hz	Single	-	3	30w	-	-	N/A	55	-	ON THE UNIT	POWER TO UNIT	
03	PIZZA OVEN FLUE ESP UNIT	PURIFIED AIR	ESP 1500EI	220 - 240v, 50Hz	Single	-	3	30w	-	-	N/A	55	-	ON THE UNIT	POWER TO UNIT	

PROPOSED PIZZA FLUE MECHANICAL DETAILS.

STUDIO72

MISSION MARSclient

RUDY'S 14 MINSTER STREET
SALISBURY SP1 1TPproject

PROPOSED PLANStitle

MM09job no

AL01 REV Bdwg no

1:50scale

TTdrawn

07377 160729mob

toby@studio-72.co.ukemail