


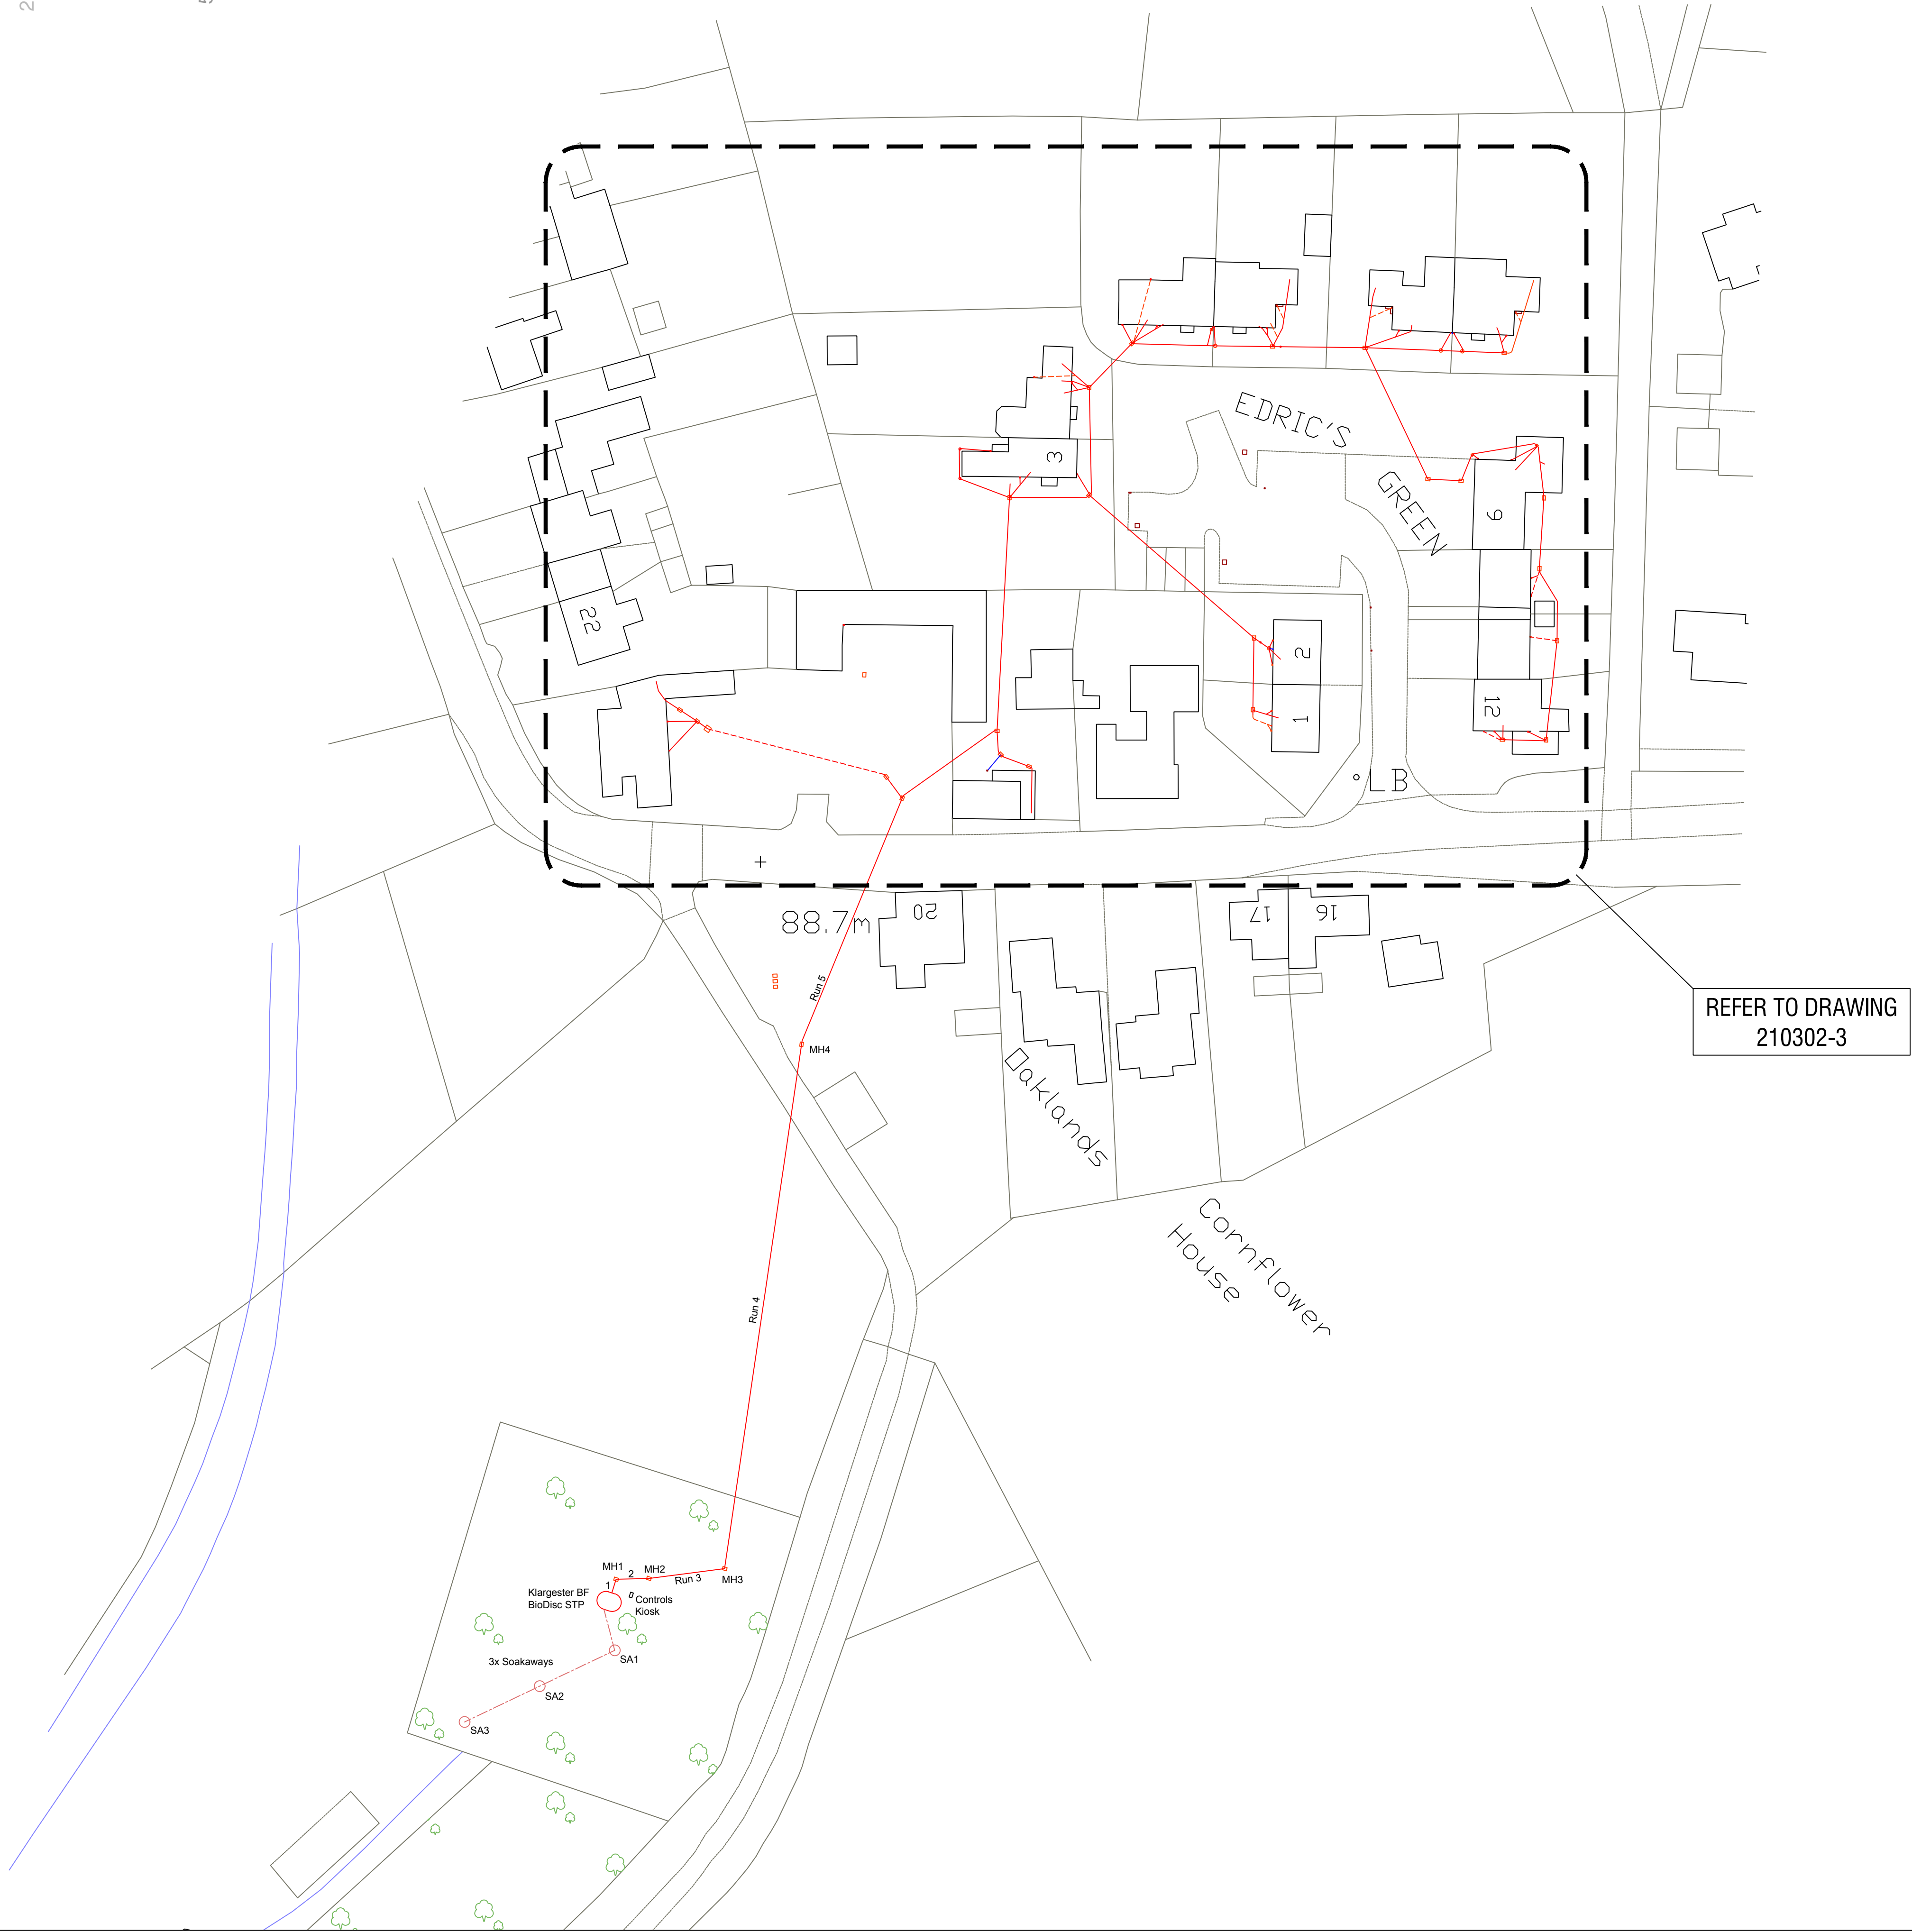

NOTES:

All dimensions must be checked on site and not scaled from this drawing.

Refer to Scantech CCTV schedule dated 31st March 2021 for further details.

LEGEND:

- Foul drainage run - as located by CCTV survey
- Presumed foul drainage run - no access for CCTV
- Rainwater drainage run
- Presumed rainwater drainage run - no access for CCTV
- Treated Foul drainage run
- Presumed Treated foul drainage run - no access for CCTV

SVP	Soil & Vent Pipe
SS	Stub Stack
VP	Vent Pipe
WG	Waste Gully
BD	Backdrop to Chamber
STP	Sewage Treatment Plant
R	Redundant
RWP/G	Rainwater Pipe / Gully (OTG - On to ground)
RG	Road Gully
YG	Yard Gully
SWG	Surface Water Gully
GT	Grease Trap
(C)	Concealed Chamber

Date	No.	Revision	Initial
© Copyright			
Armitage House Victor Jackson Avenue Poundbury Dorchester Dorset DT1 3GY Tel: 01305 757250 info@aquatechdrainage.com aquatechdrainage.com			
Client Wiltshire Council			
Job Title 1-12 Edrics Green, Holly Tree House and Holly Tree Cottage, Cholderton Salisbury SP4 ODP			
Drawing Title Existing foul water drainage layout as located by CCTV survey. Sheet 1 of 2			
© Crown Copyright 2020. All rights reserved. Licence No. OI1456118 © Philips Street Atlas Series			
Scale 1:500		Paper Size A1	
Date 30.03.21		Drawn by RPR	
Drg. No. 210302/2		Rev. .	