

| A/C units - Sleeping Area (SL) |   |
|--------------------------------|---|
| Unit type                      | U |
| SL-Indoor Unit                 | 5 |
| SL-Outdoor Unit                | 5 |

| A/C units - Activity Area (AT) |   |
|--------------------------------|---|
| Unit type                      | U |
| AT-Indoor Unit                 | 1 |
| AT-Outdoor Unit                | 1 |

- NOTES
- EACH INDOOR UNIT IS CONNECTED TO ITS CORRESPONDING OUTDOOR CONDENSER UNIT.

 
POSITION OF THE A/C UNITS TO BE CONFIRMED ON SITE.

PROVIDE CONDENSATE DRAIN TO FALL FROM INDOOR UNIT TO APPROVED WASTEPOINT.

A/C TO BE INSTALLED IN PHASES AS PER CONSTRUCTION ISSUE DRAWINGS.

This drawing is © copyright JM Design Studio Ltd 2024. No unauthorised reproduction of any kind is permitted. No dimensions to be scaled from this drawing. Verify all dimensions prior to construction. Immediately report any discrepancies on the document to JM Design Studio Ltd. This document shall be read in conjunction with all relevant Architectural, Structural, M&E, Public Health, Landscape, Civils and Interior Designer's drawings, schedules and specifications.

All figures are approximate and have been measured and expressed in a manner as defined by the current edition of the RICS Code of Measuring Practice unless otherwise stated. Figures relate to the current stage of the project and represent the design intent only; if additional information is required please contact JM Design Studio Ltd.



Cooling Legend

INDOOR UNIT

OUTDOOR UNIT

Condenser Cage

Refrigerant pipework

Condensate drainage (gravity)

Area Legend

SLEEPING AREA (SL)

ACTIVITY AREA (AT)

OUT OF SCOPE

A/C Unit Legend

Smaller Unit (SU): Fujitsu AOYG12KPCA external unit / ASYG12KPCA internal unit

Medium Unit (MU): Fujitsu AOYG24KMTA external unit / ASYG24KMTB internal unit

Larger Unit (LU): Fujitsu AOYG36LMTA external unit / ASYG36LMTA internal unit

| N° | Description           | Issue Date |
|----|-----------------------|------------|
| 4  | Issued for Planning 2 | 30/09/2026 |
| 3  | Issued for Planning   | 20/08/2026 |
| 2  | A/C Strategy Layout   | 27/07/2026 |
| 1  | A/C Strategy Layout   | 06/07/2026 |

REVISION SCHEDULE

PROJECT NAME:

Apple Tree Nursery

DRAWING CREATED BY:

JM Design Studio

DRAWING TITLE:

A/C Strategy Layout

DRAWING NUMBER:


2519-JMDS-00-ZZ-DR-A-0001-4

| SCALE: | PAPER SIZE: |  |
|--------|-------------|--|
| 1:150  | A3          |  |

| APPROVAL:    |            |             |
|--------------|------------|-------------|
| Created by:  | Date:      | Checked by: |
| AN           | 20/08/2026 | JM          |
| Approved by: | Date:      |             |
| JM           | 30/09/2026 |             |

DRAWING STATUS:

S3\_FOR REVIEW & COMMENT

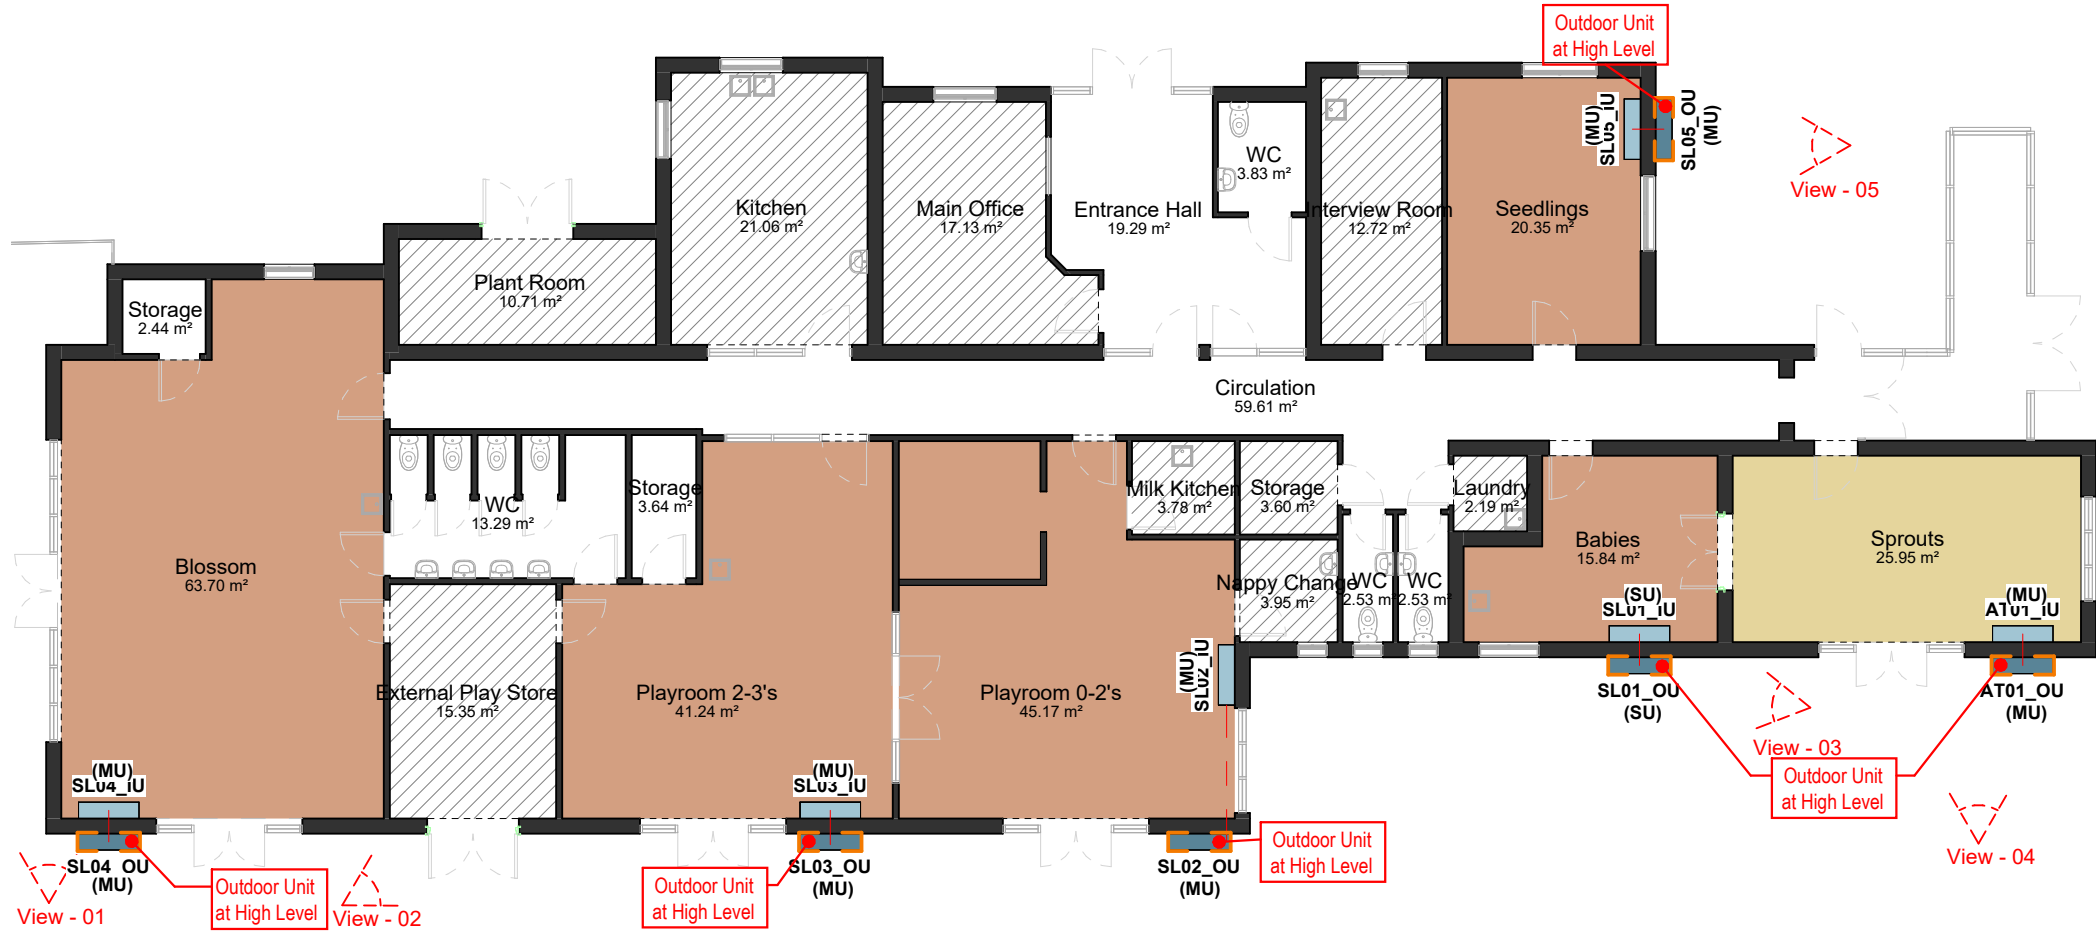


1 | A/C Plan - Ground Floor Plan

1 : 150



View - 01

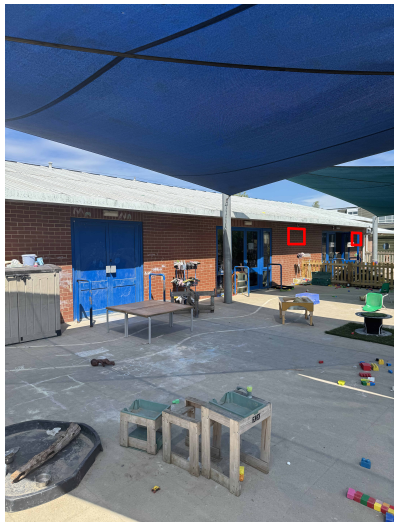

View - 02



View - 03



View - 04



View - 05