


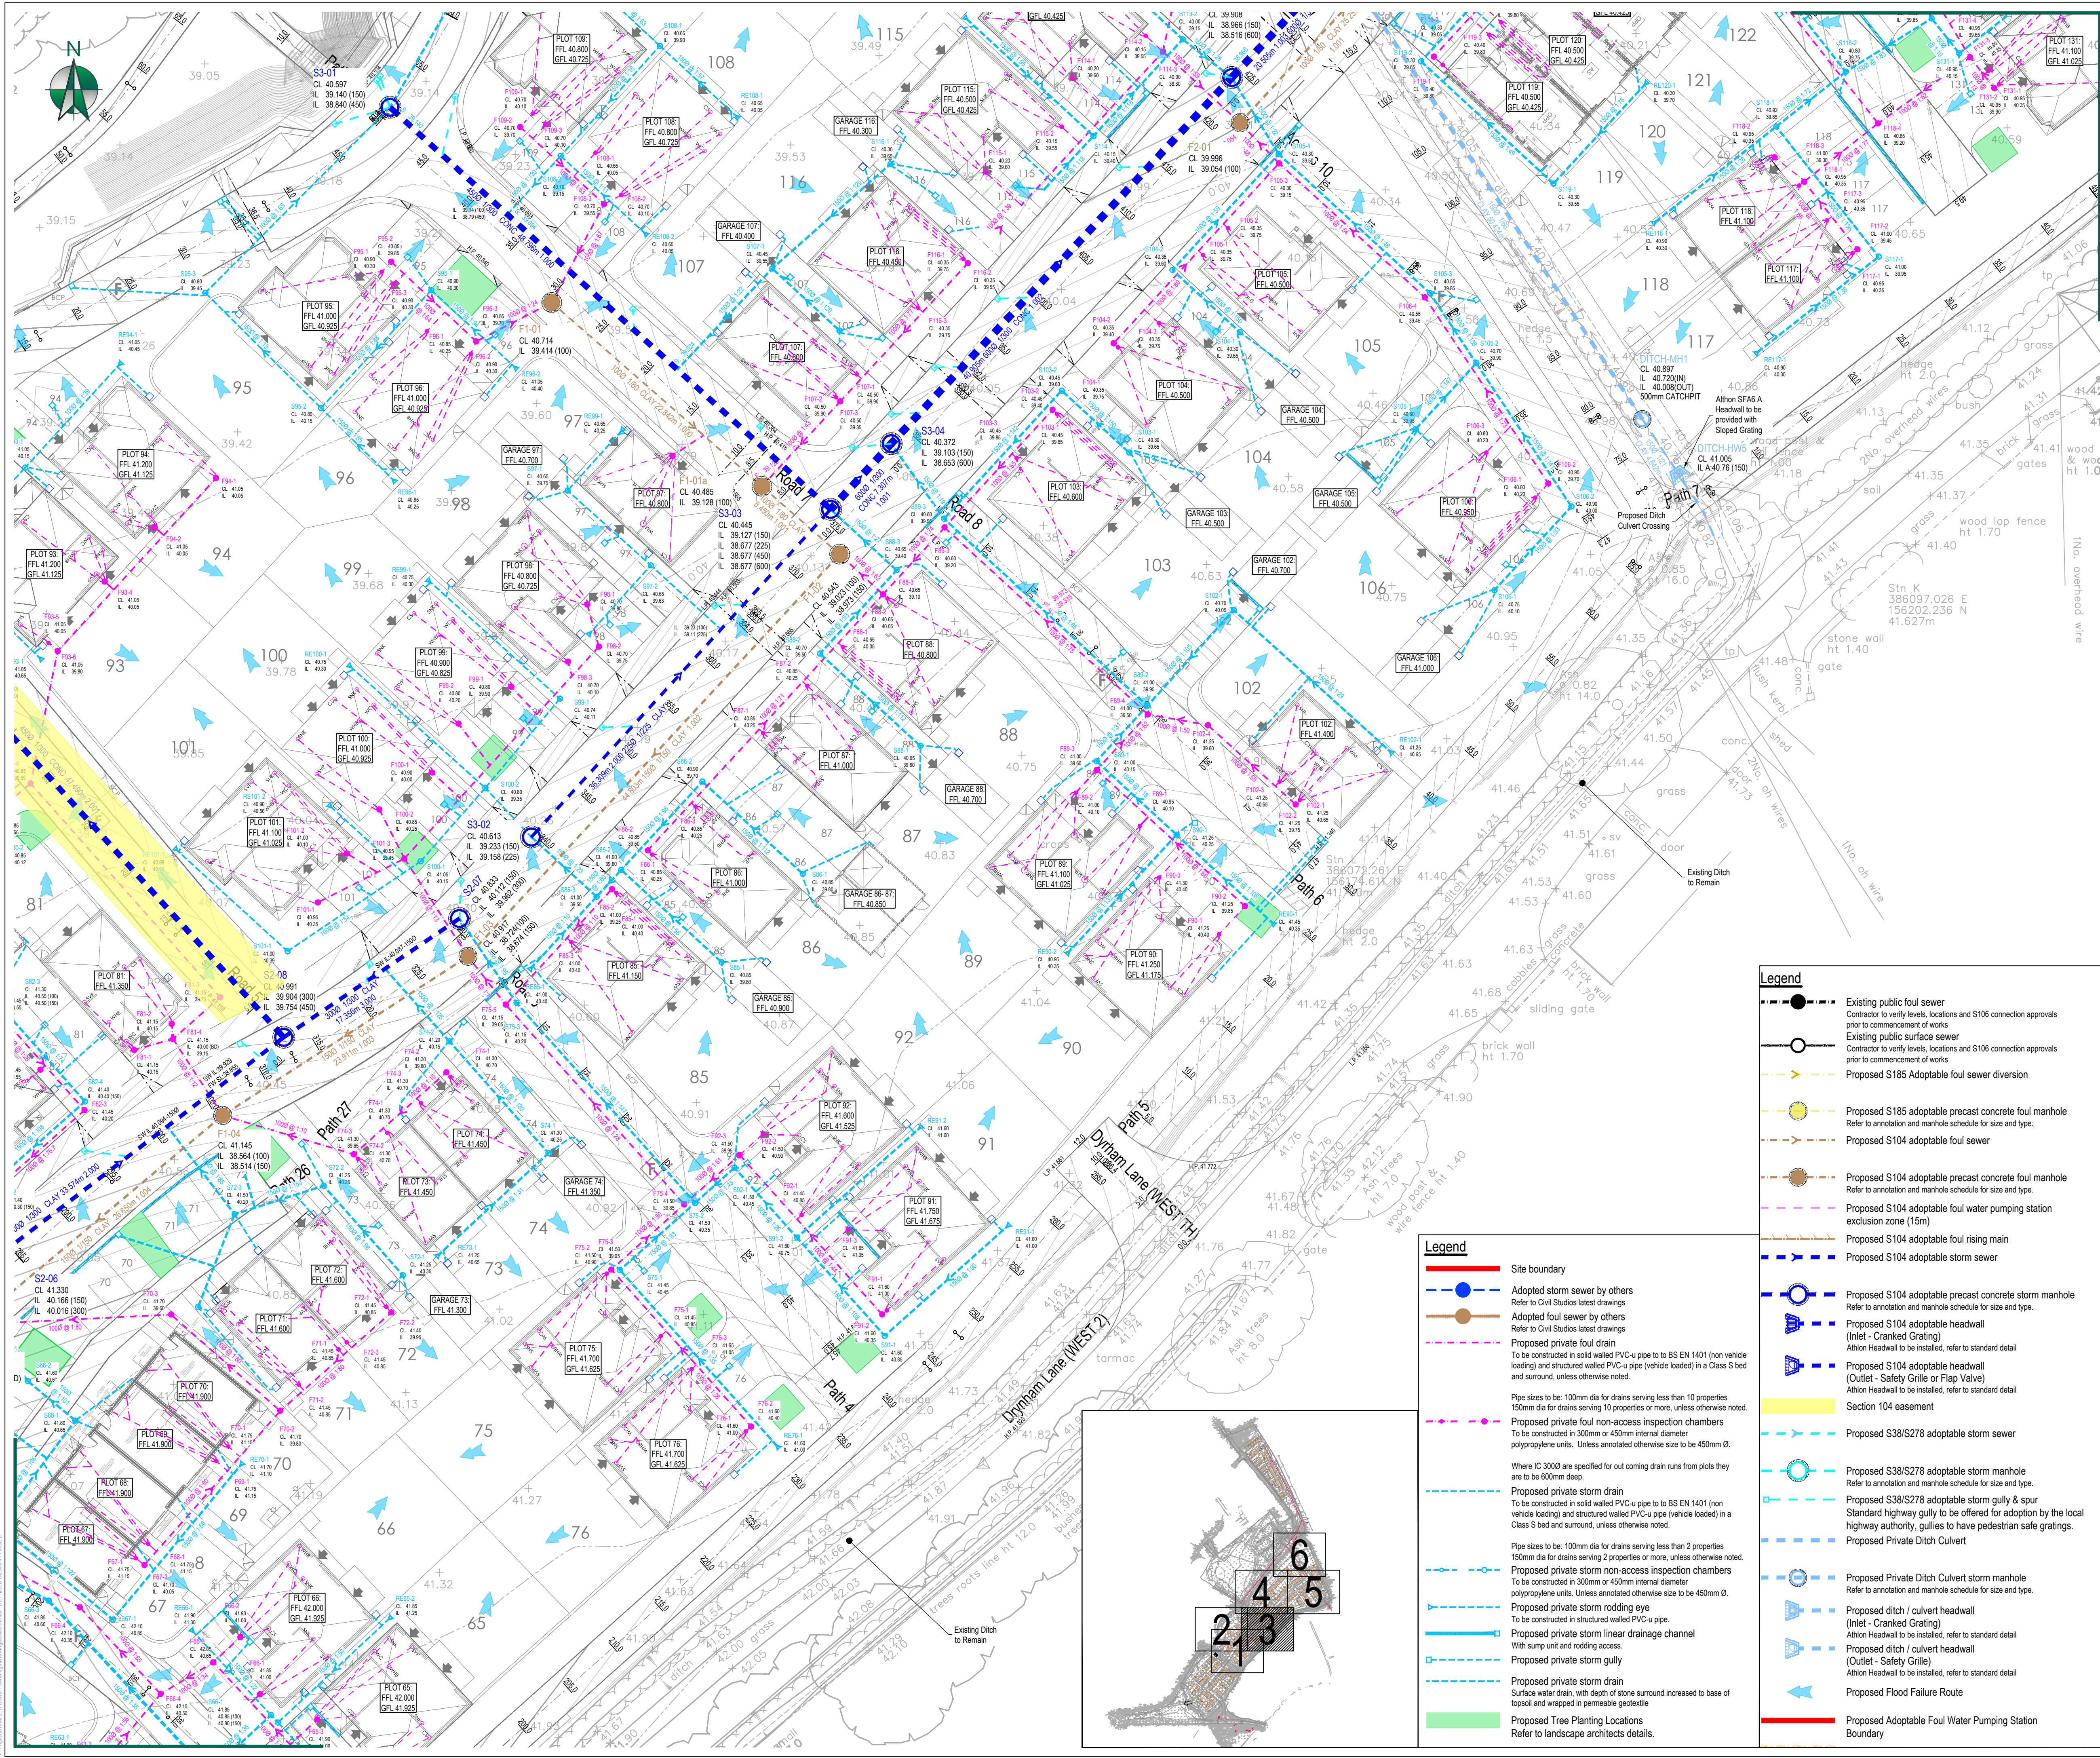

CDM: Significant Hazards

Health and Safety hazards are identified by the designer as abnormal in pursuance of the current Construction Design and Management regulations. It is assumed that all works will be carried out by competent & adequately resourced contractors working to safe systems of work.

General Notes

1. DO NOT SCALE FROM THIS DRAWING FOR CONSTRUCTION. Scaling from this drawing or obtaining dimensions electronically may not provide accurate information and should be avoided, therefore work only from figured dimensions and contact JRC Consulting Engineers.

2. This drawing is to be read in conjunction with all other relevant Architects, Engineers & Specialist drawings, details, Specification and the relevant Health and Safety Plan (as appropriate to the project). All discrepancies to be reported to the Engineer immediately for verification.

Drainage Notes

1. The planning, design and construction of sewers shall be in accordance with Sewers Sector Guidance (SSG) a design and construction guide for developers.

2. The minimum size of sewer where guide bars, safety chains, or other safety devices are required in manholes shall be 375mm diameter.

3. All type A & B manholes should have a concrete surround. Concrete rings shall be sealed using 'bakstrip' and lifting eyes pointed with resin modified mortar.

4. Compliance with health & safety matters on any trench/manhole is obligatory and a permit to enter a confined space is required when connecting site drainage to the existing public sewerage system. A permit to enter a confined space will be obtained from SWW Ltd prior to the works commencing on any public sewerage system.

5. Where the proposed site drainage connects to the public sewerage system either by new junction, new manhole or at an existing manhole, it will require the submission of an application for sewer connection form to SWW Ltd prior to works commencing.

6. MH covers and frames shall be ductile iron with a minimum square opening of 675x675mm. Covers shall be double triangle for 675mm square openings and be provided with loose bolted connections. Frame depth shall be 150mm. Covers to PPIC'S shall be in accordance with SSG. Type C manholes to be provided with 1200 x 688mm covers and opening.

7. MH covers and frames shall be ductile iron with a minimum square opening of 675x675mm. Covers shall be double triangle for 675mm square openings and be provided with loose bolted connections. Frame depth shall be 150mm. Covers to PPIC'S shall be in accordance with SSG. Type C manholes to be provided with 1200 x 688mm covers and opening.

8. The use of ladders or steps in manholes, wet wells and valve chambers shall comply with the following: steel plastic encapsulated MH single steps shall not be used in MHS of a greater depth than 1.0m. Steel plastic encapsulated double steps may be provided in MHS up to 3.0m deep. Ladders shall be provided in accordance with BS 4211 in MHS between 3.0m & 6.0m deep. MHS greater than 6.0m deep shall be specially designed and have intermediate landings. Access holes in intermediate landings shall be provided with galvanneal mild steel gratings to prevent persons falling through. The design of deep manholes shall permit the use of a winch or lifting gear mounted at ground level in case of emergencies.

9. Only low carbon steel or stainless-steel ladders for vertical fixing to manholes will be acceptable.

10. Proposed adoptable sewers are only permitted to have other sewer/gully connections and other services laid at an angle of between 45 degrees and 90 degrees across the line with a vertical clearance more than 300mm.

11. All ironwork to be kited marked by BSI or certified by equal inspection authority.

12. Red coloured plastic marker tape at least 150mm wide shall be laid at a minimum of 200mm above the soffit of the pipe. The tape shall be printed with the words 'gravity sewer' in bold capital letters throughout its length and at intervals not exceeding 700mm and shall incorporate a corrosion resistant tracing system for non-metallic pipes.

13. Minimum backdrop height shall be 1m.

14. On new drainage schemes, the first manhole upstream from the connection to the existing foul water sewer shall be fitted with a suitable screen, which will remain in place until the new sewer becomes live.

Drainage Notes - DCG

1. Drawings to be read in conjunction with all design drawings and building regulations

2. All levels are to be Ordinance Survey datum levels.

3. All materials used in connection with this design must:

- Not be detrimental to health & safety or adversely affect durability of the construction.
- Where applicable, be compliant to current British/European Standards, Codes of Practice and good building practice.

4. The planning, design and construction of sewers shall be in accordance with Design and Construction Guidance (DCG) for foul and surface water sewers offered for adoption under the Code for adoption agreements for water and sewerage companies in England.

5. The minimum size of sewer where guide bars, safety chains, or other safety devices are required in manholes shall be 375mm diameter.

6. All type A & B manholes should have a concrete surround. Concrete rings shall be sealed using 'bakstrip' and lifting eyes pointed with resin modified mortar. PPIC'S should be installed in accordance with the DCG.

7. Compliance with health & safety matters on any trench/manhole is obligatory and a permit to enter a confined space is required when connecting site drainage to the existing public sewerage system. A permit to enter a confined space will be obtained from the local water company prior to the works commencing on any public sewerage system.

8. Where the proposed site drainage connects to the public sewerage system either by new junction, new manhole or at an existing manhole, it will require the submission of an application for sewer connection form to the local water company prior to works commencing.

9. MH covers and frames shall be ductile iron with a minimum square opening of 675x675mm. Covers shall be double triangle for 675mm square openings and be provided with loose bolted connections. Frame depth shall be 150mm. Covers to PPIC'S shall be in accordance with the DCG.

10. The use of ladders or steps in manholes, wet wells and valve chambers shall comply with the following: steel plastic encapsulated MH single steps shall not be used in MHS of a greater depth than 1.0m. Steel plastic encapsulated double steps may be provided in MHS up to 3.0m deep. Ladders shall be provided in accordance with BS 4211 in MHS between 3.0m & 6.0m deep. MHS greater than 6.0m deep shall be specially designed and have intermediate landings. Access holes in intermediate landings shall be provided with galvanneal mild steel gratings to prevent persons falling through. The design of deep manholes shall permit the use of a winch or lifting gear mounted at ground level in case of emergencies.

11. Only low carbon steel or stainless-steel ladders for vertical fixing to manholes will be acceptable.

12. Proposed adoptable sewers are only permitted to have other sewer/gully connections and other services laid at an angle of between 45 degrees and 90 degrees across the line with a vertical clearance more than 300mm.

13. All ironwork to be kited marked by BSI or certified by equal inspection authority.

14. Red coloured plastic marker tape at least 150mm wide shall be laid at a minimum of 200mm above the soffit of the pipe. The tape shall be printed with the words 'gravity sewer' in bold capital letters throughout its length and at intervals not exceeding 700mm and shall incorporate a corrosion resistant tracing system for non-metallic pipes.

15. Minimum backdrop height shall be 1m.

16. On new drainage schemes, the first manhole upstream from the connection to the existing foul water sewer shall be fitted with a suitable screen, which will remain in place until the new sewer becomes live. For type 3 manholes, outlet to be bunged with suitable stopper and chain which can be removed on completion of work.

17. Adopted pipework bed surround:

- Vehicular access: <1200 cover Class Z concrete >1200 cover Class S granular
- Non-vehicular access: <600 Cover Class Z concrete >600 Cover Class S granular

Legend

Existing public foul sewer  
Contractor to verify levels, locations and S106 connection approvals prior to commencement of works

Existing public surface sewer  
Contractor to verify levels, locations and S106 connection approvals prior to commencement of works

Proposed S185 Adoptable foul sewer diversion

Proposed S185 adoptable precast concrete foul manhole  
Refer to annotation and manhole schedule for size and type

Proposed S104 adoptable foul sewer

Proposed S104 adoptable precast concrete foul manhole  
Refer to annotation and manhole schedule for size and type

Proposed S104 adoptable foul water pumping station exclusion zone (15m)

Proposed S104 adoptable foul rising main

Proposed S104 adoptable storm sewer

Proposed S104 adoptable precast concrete storm manhole  
Refer to annotation and manhole schedule for size and type

Proposed S104 adoptable headwall (Inlet - Cranked Grating)  
A100 Headwall to be installed, refer to standard detail

Proposed S104 adoptable headwall (Outlet - Safety Grille or Flap Valve)  
A100 Headwall to be installed, refer to standard detail

Section 104 easement

Proposed S38/S278 adoptable storm sewer

Proposed S38/S278 adoptable storm manhole  
Refer to annotation and manhole schedule for size and type

Proposed S38/S278 adoptable storm gully & spur  
Standard highway gully to be offered for adoption by the local highway authority, gullies to have pedestrian safe gratings.

Proposed Private Ditch Culvert

Proposed Private Ditch Culvert storm manhole  
Refer to annotation and manhole schedule for size and type

Proposed ditch / culvert headwall (Inlet - Cranked Grating)  
A100 Headwall to be installed, refer to standard detail

Proposed ditch / culvert headwall (Outlet - Safety Grille)  
A100 Headwall to be installed, refer to standard detail

Proposed Flood Failure Route

Proposed Adoptable Foul Water Pumping Station Boundary

Legend

Site boundary

Adopted storm sewer by others  
Refer to Civil Studios latest drawings

Adopted foul sewer by others  
Refer to Civil Studios latest drawings

Proposed private foul drain  
To be constructed in solid walled PVC-U pipe to BS EN 1401 (non vehicle loading) and structured walled PVC-U pipe (vehicle loaded) in a Class S bed and surround, unless otherwise noted.

Pipe sizes to be: 100mm dia for drains serving less than 10 properties  
150mm dia for drains serving 10 properties or more, unless otherwise noted.

Proposed private foul non-access inspection chambers  
To be constructed in 300mm or 450mm internal diameter polypropylene units. Unless annotated otherwise size to be 450mm Ø.

Where IC 3000 are specified for out coming drain runs from plots they are to be 600mm deep.

Proposed private storm drain  
To be constructed in solid walled PVC-U pipe to BS EN 1401 (non vehicle loading) and structured walled PVC-U pipe (vehicle loaded) in a Class S bed and surround, unless otherwise noted.

Pipe sizes to be: 100mm dia for drains serving less than 2 properties  
150mm dia for drains serving 2 properties or more, unless otherwise noted.

Proposed private storm non-access inspection chambers  
To be constructed in 300mm or 450mm internal diameter polypropylene units. Unless annotated otherwise size to be 450mm Ø.

Proposed private storm rodding eye  
To be constructed in structured walled PVC-U pipe.

Proposed private storm linear drainage channel  
With sump unit and rodding access.

Proposed private storm gully

Proposed private storm drain  
Surface water drain, with depth of stone surround increased to base of topsoil and wrapped in permeable geotextile.

Proposed Tree Planting Locations  
Refer to landscape architects details.

Legend

Proposed S104 adoptable precast concrete storm manhole  
Refer to annotation and manhole schedule for size and type

Proposed S104 adoptable headwall (Inlet - Cranked Grating)  
A100 Headwall to be installed, refer to standard detail

Proposed S104 adoptable headwall (Outlet - Safety Grille or Flap Valve)  
A100 Headwall to be installed, refer to standard detail

Section 104 easement

Proposed S38/S278 adoptable storm sewer

Proposed S38/S278 adoptable storm manhole  
Refer to annotation and manhole schedule for size and type

Proposed S38/S278 adoptable storm gully & spur  
Standard highway gully to be offered for adoption by the local highway authority, gullies to have pedestrian safe gratings.

Proposed Private Ditch Culvert

Proposed Private Ditch Culvert storm manhole  
Refer to annotation and manhole schedule for size and type

Proposed ditch / culvert headwall (Inlet - Cranked Grating)  
A100 Headwall to be installed, refer to standard detail

Proposed ditch / culvert headwall (Outlet - Safety Grille)  
A100 Headwall to be installed, refer to standard detail

Proposed Flood Failure Route

Proposed Adoptable Foul Water Pumping Station Boundary

Legend

Site boundary

Adopted storm sewer by others  
Refer to Civil Studios latest drawings

Adopted foul sewer by others  
Refer to Civil Studios latest drawings

Proposed private foul drain  
To be constructed in solid walled PVC-U pipe to BS EN 1401 (non vehicle loading) and structured walled PVC-U pipe (vehicle loaded) in a Class S bed and surround, unless otherwise noted.

Pipe sizes to be: 100mm dia for drains serving less than 10 properties  
150mm dia for drains serving 10 properties or more, unless otherwise noted.

Proposed private foul non-access inspection chambers  
To be constructed in 300mm or 450mm internal diameter polypropylene units. Unless annotated otherwise size to be 450mm Ø.

Where IC 3000 are specified for out coming drain runs from plots they are to be 600mm deep.

Proposed private storm drain  
To be constructed in solid walled PVC-U pipe to BS EN 1401 (non vehicle loading) and structured walled PVC-U pipe (vehicle loaded) in a Class S bed and surround, unless otherwise noted.

Pipe sizes to be: 100mm dia for drains serving less than 2 properties  
150mm dia for drains serving 2 properties or more, unless otherwise noted.

Proposed private storm non-access inspection chambers  
To be constructed in 300mm or 450mm internal diameter polypropylene units. Unless annotated otherwise size to be 450mm Ø.

Proposed private storm rodding eye  
To be constructed in structured walled PVC-U pipe.

Proposed private storm linear drainage channel  
With sump unit and rodding access.

Proposed private storm gully

Proposed private storm drain  
Surface water drain, with depth of stone surround increased to base of topsoil and wrapped in permeable geotextile.

Proposed Tree Planting Locations  
Refer to landscape architects details.

Legend

Proposed S104 adoptable precast concrete storm manhole  
Refer to annotation and manhole schedule for size and type

Proposed S104 adoptable headwall (Inlet - Cranked Grating)  
A100 Headwall to be installed, refer to standard detail

Proposed S104 adoptable headwall (Outlet - Safety Grille or Flap Valve)  
A100 Headwall to be installed, refer to standard detail

Section 104 easement

Proposed S38/S278 adoptable storm sewer

Proposed S38/S278 adoptable storm manhole  
Refer to annotation and manhole schedule for size and type

Proposed S38/S278 adoptable storm gully & spur  
Standard highway gully to be offered for adoption by the local highway authority, gullies to have pedestrian safe gratings.

Proposed Private Ditch Culvert

Proposed Private Ditch Culvert storm manhole  
Refer to annotation and manhole schedule for size and type

Proposed ditch / culvert headwall (Inlet - Cranked Grating)  
A100 Headwall to be installed, refer to standard detail

Proposed ditch / culvert headwall (Outlet - Safety Grille)  
A100 Headwall to be installed, refer to standard detail

Proposed Flood Failure Route

Proposed Adoptable Foul Water Pumping Station Boundary

Legend

Site boundary

Adopted storm sewer by others  
Refer to Civil Studios latest drawings

Adopted foul sewer by others  
Refer to Civil Studios latest drawings

Proposed private foul drain  
To be constructed in solid walled PVC-U pipe to BS EN 1401 (non vehicle loading) and structured walled PVC-U pipe (vehicle loaded) in a Class S bed and surround, unless otherwise noted.

Pipe sizes to be: 100mm dia for drains serving less than 10 properties  
150mm dia for drains serving 10 properties or more, unless otherwise noted.

Proposed private foul non-access inspection chambers  
To be constructed in 300mm or 450mm internal diameter polypropylene units. Unless annotated otherwise size to be 450mm Ø.

Where IC 3000 are specified for out coming drain runs from plots they are to be 600mm deep.

Proposed private storm drain  
To be constructed in solid walled PVC-U pipe to BS EN 1401 (non vehicle loading) and structured walled PVC-U pipe (vehicle loaded) in a Class S bed and surround, unless otherwise noted.

Pipe sizes to be: 100mm dia for drains serving less than 2 properties  
150mm dia for drains serving 2 properties or more, unless otherwise noted.

Proposed private storm non-access inspection chambers  
To be constructed in 300mm or 450mm internal diameter polypropylene units. Unless annotated otherwise size to be 450mm Ø.

Proposed private storm rodding eye  
To be constructed in structured walled PVC-U pipe.

Proposed private storm linear drainage channel  
With sump unit and rodding access.

Proposed private storm gully

Proposed private storm drain  
Surface water drain, with depth of stone surround increased to base of topsoil and wrapped in permeable geotextile.

Proposed Tree Planting Locations  
Refer to landscape architects details.

Legend

Proposed S104 adoptable precast concrete storm manhole  
Refer to annotation and manhole schedule for size and type

Proposed S104 adoptable headwall (Inlet - Cranked Grating)  
A100 Headwall to be installed, refer to standard detail

Proposed S104 adoptable headwall (Outlet - Safety Grille or Flap Valve)  
A100 Headwall to be installed, refer to standard detail

Section 104 easement

Proposed S38/S278 adoptable storm sewer

Proposed S38/S278 adoptable storm manhole  
Refer to annotation and manhole schedule for size and type

Proposed S38/S278 adoptable storm gully & spur  
Standard highway gully to be offered for adoption by the local highway authority, gullies to have pedestrian safe gratings.

Proposed Private Ditch Culvert

Proposed Private Ditch Culvert storm manhole  
Refer to annotation and manhole schedule for size and type

Proposed ditch / culvert headwall (Inlet - Cranked Grating)  
A100 Headwall to be installed, refer to standard detail

Proposed ditch / culvert headwall (Outlet - Safety Grille)  
A100 Headwall to be installed, refer to standard detail

Proposed Flood Failure Route

Proposed Adoptable Foul Water Pumping Station Boundary

REV. DATE DETAILS

C3 17.07.26 Drawing update following client comments

C2 04.11.25 Revised to suit landscaping areas

C1 30.09.25 First Issue

AC JDC

JDC DWJ/P

JDC DWJ/P

REV. DATE DETAILS

C3 17.07.26 Drawing update following client comments

C2 04.11.25 Revised to suit landscaping areas

C1 30.09.25 First Issue

AC JDC

JDC DWJ/P

JDC DWJ/P

JRC CONSULTING

Exeter Office: 01392 927330  
Bideford Office: 01227 520330  
Web: www.jrcconsulting.co.uk

DRAWING STATUS

FOR CONSTRUCTION

PROJECT

ELM GROVE TROWBRIDGE

CLIENT

REDROW

DRAWING TITLE

Drainage Layout  
PHASE 2  
SHEET 3

SCALE @ A1

0m 1:250 10m

SIZE A1

DATE SEP 25

PROJECT NUMBER 1960

DRAWING NUMBER 2503

REVISION C3

THIS DRAWING IS THE COPYRIGHT © OF JRC CONSULTING ENGINEERS LTD AND MUST NOT BE COPIED, REPRODUCED OR SUBMITTED TO OTHER PARTIES WITHOUT THEIR PERMISSION